

ADDENDUM NUMBER - 1

OWNER: N. P. Dodge
8701 West Dodge Road
Omaha, NE

ARCHITECT: Stanley J. How Architects, Inc.
14685 California Street
Omaha, Nebraska 68154

DATE: August 5, 2024

JOB NO.: 2020-25

The following changes, corrections, clarifications and additions shall be made to the plans and specifications for:

**Proposed Mexican Restaurant
8601 West Dodge Road, Suite 101
Omaha, NE**

and shall be as binding as if incorporated in the original plans and specifications. All Contractors shall acquaint themselves with all aspects of this Addendum.

All other provisions and stipulations of the Contract Documents remain in effect.

This Addendum shall be attached to and made a part of the Contract Documents and its receipt shall be acknowledged where specified in the Bidder's Proposal.

ITEM NO. 1: Sheet E1.1, Lighting Fixture Schedule: Added note #7 noting an "as equal" manufacturer.

LIGHTING CONTROL DEVICE SCHEDULE (NOTE 1)


SYMBOL	MANUFACTURER	CATALOG NUMBER	DESCRIPTION
[E]	SENSORSWITCH	nECY MVOLT ENC GFXX	LIGHTING CONTROL NETWORK SYSTEM BACKBONE
[I]	SENSORSWITCH	nPOOM TOUCH	GRAPHICAL INTERFACE
[K]	SENSORSWITCH	WSX PDT XX	LINE VOLTAGE SINGLE POLE WALL BOX OCCUPANCY SENSOR
[PP10]	SENSORSWITCH	nPP16 DS	LIGHTING CONTROL NETWORK POWER PACK - WITH DIMMING (NOTE 2)
[PP15M]	SENSORSWITCH	nPP16 ER	LIGHTING CONTROL NETWORK POWER PACK - NO DIMMING, WITH UL924 EMERGENCY OPERATION

NOTES:
 1. PRODUCTS LISTED INDICATE BASIS OF DESIGN PRODUCTS. REFER TO SPECIFICATIONS FOR ACCEPTABLE EQUIVALENT MANUFACTURERS.
 2. COORDINATE DIMMING TYPE REQUIRED WITH ASSOCIATED LIGHT FIXTURE TYPE CONTROLLED.

LIGHTING FIXTURE SCHEDULE

FIXT #	MANUFACTURER	CATALOG NO. (NOTE 2)	LAMP DATA		VOLTAGE	MOUNTING		DESCRIPTION	REMARKS
			QTY.	SIZE		TYPE (NOTE 3)	HEIGHT		
1	LITHONIA, NOTE 1	EPANL 2X4 6000LM 80CRI 40K MIN10 ZT MVOLT	N/A	6,000 LM / 4000K	LED	120/277	X X	2X4 FLAT PANEL	
1E	LITHONIA, NOTE 1	EPANL 2X4 6000LM 80CRI 40K MIN10 ZT MVOLT EL14L	N/A	6,000 LM / 4000K	LED	120/277	X X	2X4 FLAT PANEL	WITH EM BATTERY
2	LITHONIA, NOTE 1	LDN4CYL 3015104AR LSS MVOLT GZ10 PM DBL	N/A	1,500LM / 3000K	LED	120/277	X X	BLACK 4IN CYLINDER	WITH EM HEADS
3	LITHONIA	LHOM LED B R HO	N/A	N/A	LED	120/277	X X	EXIT LIGHT	WITH EM HEADS
4	LITHONIA	ELM2L B	N/A	N/A	LED	120/277	X X	EM BATTERY LIGHT	WITH EM BATTERY
5	LITHONIA, NOTE 1	LDN4 3915104AR LSS MVOLT E21	N/A	1,500LM / 3000K	LED	120/277	X X	4IN DOWN LIGHT	
6	LITHONIA, NOTE 1	EPANL 2X4 6000LM 80CRI 40K MIN10 ZT MVOLT 2X4SKSH	N/A	6,000 LM / 4000K	LED	120/277	X X	2X4 FLAT PANEL	
6E	LITHONIA, NOTE 1	EPANL 2X4 6000LM 80CRI 40K MIN10 ZT MVOLT EL14L 2X4SKSH	N/A	6,000 LM / 4000K	LED	120/277	X X	2X4 FLAT PANEL	WITH EM BATTERY
7	BL LIGHTING, NOTE 7	BL FLEXFORM D2 30 65 BL DRIVELINE MG 9610	-	200 LWF7 / 3000K	-	120	X	TAPE LIGHT	NOTE 4
8	LITHONIA	WPX1 LED P1 30K MVOLT DBL20	N/A	2,900 LM / 3000K	LED	120/277	X X	WALL PACK	NOTE 5
9	ALPHABET	750X 30K VA PC XX XX	N/A	170 LM / 3000K	LED	120/277	X X	RAIL LIGHT	NOTE 6
10	LITHONIA	WLTE B 1 R EL	N/A	N/A	LED	120/277	X X	EXIT LIGHT	WITH EM HEADS

NOTES:
 1. FIXTURE SHALL BE CONSIDERED EQUAL AS MANUFACTURED BY COLUMBIA, DAY-BRITE, COOPER, AND H.E. WILLIAMS.
 2. CONTRACTOR SHALL VERIFY LIGHT FIXTURE CATALOG NUMBER & INSTALLATION REQUIREMENTS PRIOR TO ORDERING.
 3. LAMP TYPE DESCRIPTION: LED-LIGHT EMITTING DIODE
 4. REFER TO ARCHITECTURAL PLANS FOR RUN LENGTHS REQUIRED. LUMINAIRE SHALL BE CONTINUOUS FOR ENTIRE LENGTHS. PROVIDE ACCESSORY MOUNTING CABLE AND ALL REQUIRED HARDWARE FOR INSTALLATION PER MANUFACTURER'S INSTRUCTIONS.
 5. SEE ARCHITECTURAL DRAWINGS FOR EXACT LOCATION AND MOUNTING HEIGHT.
 6. COORDINATE BEZEL, COLOR, FACE TYPE AND INSTALLATION OF LIGHT WITH ARCHITECT, RAILING VENDOR AND GENERAL CONTRACTOR PRIOR TO ROUGH IN.
 7. FIXTURE SHALL BE CONSIDERED EQUAL AS MANUFACTURED BY LLI LIGHTING.

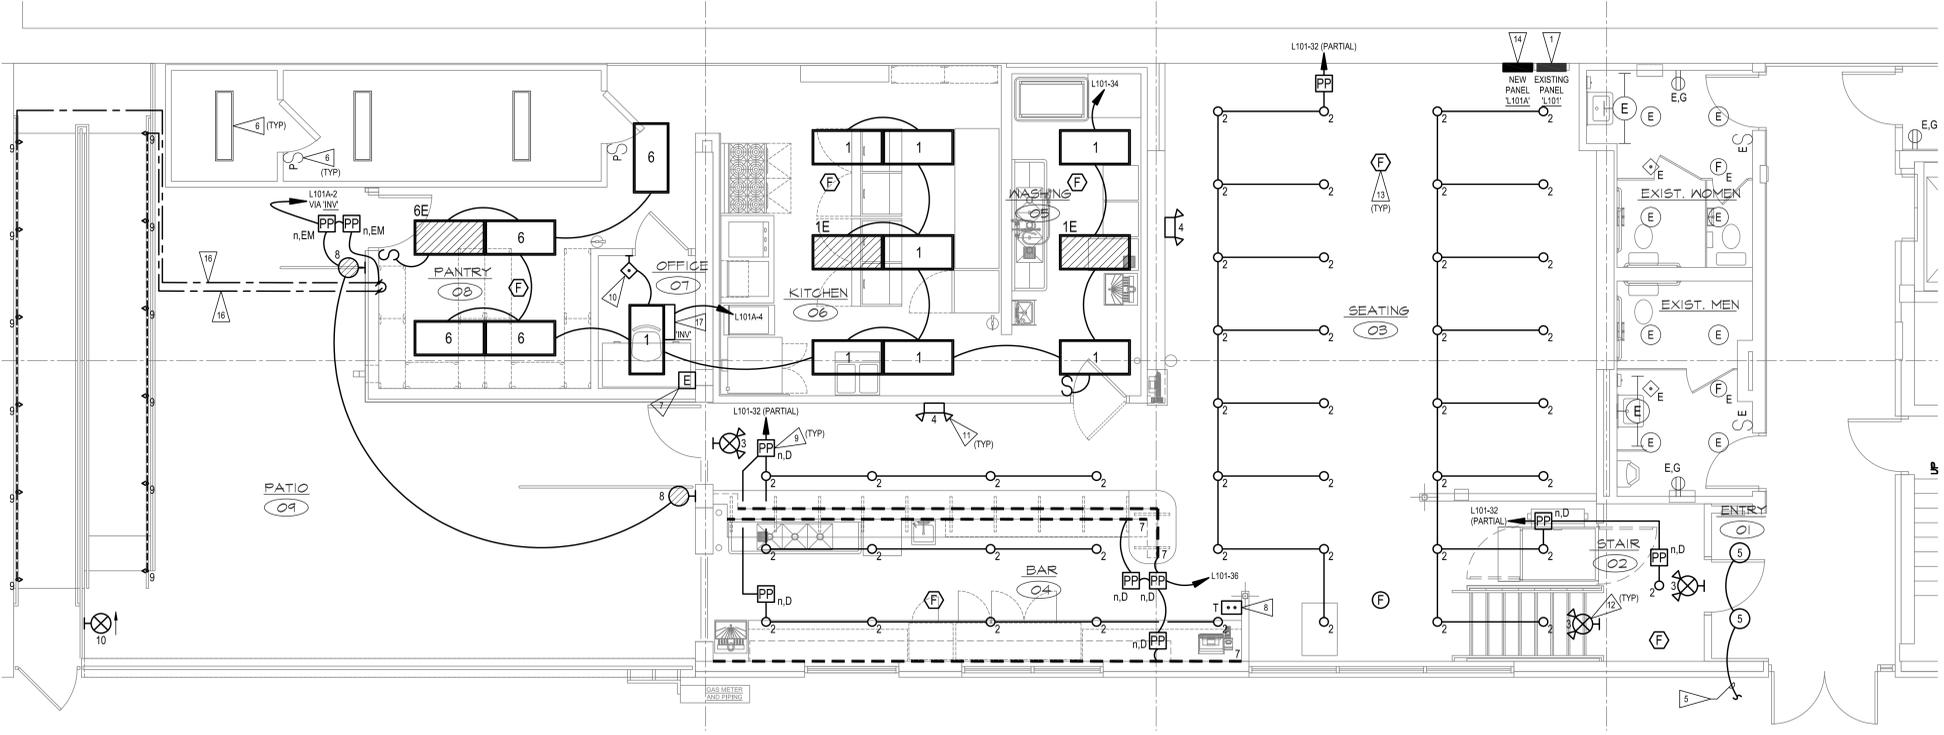


FLOOR PLAN - LIGHTING
 SCALE: 1'-0" = 1'-0"
 SCALE: 1/4" = 1'-0"


KITCHEN EQUIPMENT CONNECTION SCHEDULE

MARK	ITEM	VOLTAGE	PH	HP (KW)	AMPS	BREAKER	CONNECTION	RECEPTACLE CONFIGURATION	MOUNTING HEIGHT	WIRE	GROUND WIRE	CONDUIT	CIRCUIT
1	SODA DISPENSER	120	1	3.2	201		X	5-20R	48"	#12	#12	3/4"	L101A-9
2	CONVECTION OVEN	120	1	8.0	201		X	5-20R	48"	#12	#12	3/4"	L101-11
3	GLASS CHILLER	120	1	2.5	201		X	5-20R	16"	#12	#12	3/4"	L101-15
4	ICE MACHINE	120	1	5.9	201		X	5-20R	48"	#12	#12	3/4"	L101-17
5	PREP TABLE	120	1	4.4	201		X	5-20R	48"	#12	#12	3/4"	L101-19
6	PREP TABLE	120	1	4.4	201		X	5-20R	48"	#12	#12	3/4"	L101-21
7	RANGE	120	1	6.0	201		X	5-20R	16"	#12	#12	3/4"	L101-23
8	REACH IN FREEZER	120	1	4.2	201		X	5-20R	NOTE 2	#12	#12	3/4"	L101-27
9	BACK BAR COOLER	120	1	10.7	201		X	5-20R	16"	#12	#12	3/4"	L101-29
10	GLASS WASHER	208	1	32.2	452	X			16"	#8	#10	1"	L101-31
11	DISH WASHER	120	1	26.0	352	X			16"	#8	#10	1"	L101-35
12	SODA DISPENSER	120	1	3.2	201		X	5-20R	48"	#12	#12	3/4"	L101A-15

KITCHEN EQUIPMENT CONNECTION SCHEDULE NOTES:
 1. INFORMATION INCLUDED IN SCHEDULE HAS BEEN BASED ON LIMITED DESIGN INFORMATION AVAILABLE AT TIME OF CONSTRUCTION DOCUMENTS. COORDINATE EQUIPMENT LOCATIONS, CONDUIT ROUTING, DEVICE MOUNTING HEIGHTS AND POWER CONNECTIONS INCLUDING VOLTAGE, PHASE, BREAKER, CONDUCTOR, CONDUIT AND RECEPTACLE CONFIGURATION WITH WITH OWNER, KITCHEN EQUIPMENT SUPPLIER AND REVIEWED KITCHEN EQUIPMENT SUBMITTALS PRIOR TO ROUGH IN AND PURCHASE OF LONG LEAD TIME EQUIPMENT. COORDINATE ANY CHANGES REQUIRED TO THE INFORMATION ABOVE WITH THE ENGINEER OF RECORD. MAKE ANY CHANGES REQUIRED AT NO ADDITIONAL COST TO OWNER.
 2. SEE DETAIL 3E2-1 FOR ADDITIONAL INFORMATION.

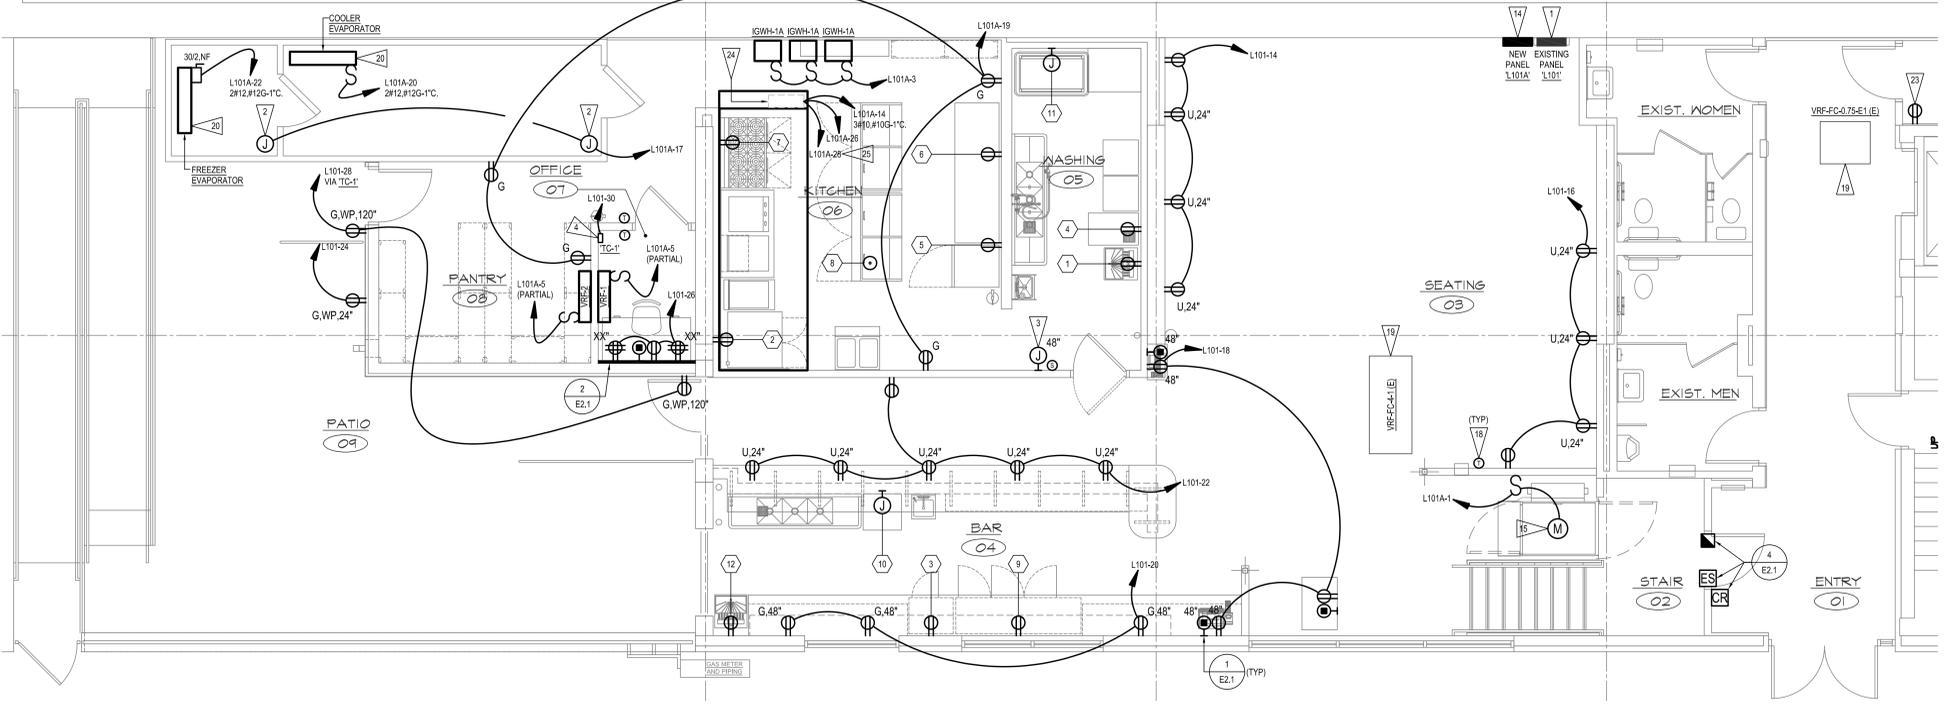

FLOOR PLAN - POWER
 SCALE: 1'-0" = 1'-0"
 SCALE: 1/4" = 1'-0"

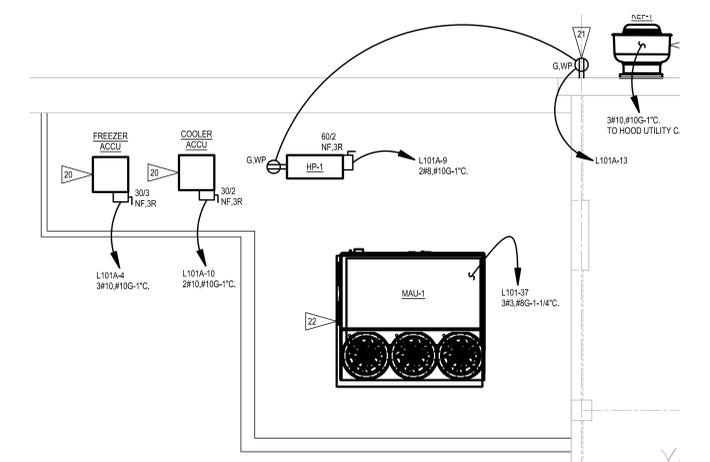

PARTIAL ROOF PLAN - POWER
 SCALE: 1'-0" = 1'-0"
 SCALE: 1/4" = 1'-0"

FLAG NOTES

- EXISTING PANEL BOARD SERVING AREA OF REMODEL. REUSE EXISTING CIRCUITS WHERE POSSIBLE. PROVIDE NEW BREAKERS AS REQUIRED TO ACCOMMODATE REMODEL. PROVIDE AN UPDATED TYPED CIRCUIT DIRECTORY AFTER REMODEL IS COMPLETE.
- PROVIDE FINAL CONNECTION TO WALK IN EQUIPMENT INTERIOR LIGHTING. PRESSURE RELIEF PORTS, DOOR HEATERS, PILOT LIGHT SWITCH, ETC. FIELD COORDINATE EXACT ELECTRICAL REQUIREMENTS BRANCH CIRCUIT SIZE, OVER CURRENT PROTECTION DEVICE SIZE, LOCAL DISCONNECTING MEANS SIZE, ETC., WITH EQUIPMENT MANUFACTURER PRIOR TO ROUGH IN.
- PROVIDE TWO DEAD FRONT REMOTE 'GFCI' DEVICES TO PROVIDE 'GFCI' PROTECTION OF THE TWO BRANCH CIRCUITS SERVING EQUIPMENT UNDER THE HOOD.
- PROVIDE NEW TWO CHANNEL, SEVEN DAY DIGITAL TIME CLOCK - TORK HDG SERIES OR EQUAL. COORDINATE TIME CLOCK LOCATION WITH OWNER PRIOR TO ROUGH IN. PROVIDE 120V CONNECTION TO TIME CLOCK.
- CONNECT NEW DOWN LIGHTING IN EXISTING VESTIBULE TO EXISTING VESTIBULE LIGHTING.
- INSTALL AND CONNECT LIGHT FIXTURES AND SWITCHES FURNISHED WITH WALK IN REFRIGERATION EQUIPMENT. SEE POWER PLAN FOR ADDITIONAL INFORMATION.
- PROVIDE LIGHTING CONTROL NETWORK SYSTEM BACKBONE WITH REQUIRED QUANTITY OF BRIDGES AND POWER PACK(S) - nLIGHT nECY MVOLT ENC GFXX. PROVIDE 120V CONNECTION WITH LOCKABLE CIRCUIT BREAKER. NEATLY ARRANGE ASSOCIATED DEVICES ADJACENT TO SYSTEM BACKBONE. SEE SPECIFICATIONS FOR ADDITIONAL INFORMATION.
- PROVIDE LIGHTING CONTROL NETWORK ENTRY STATION - SEE LIGHTING CONTROL DEVICE SCHEDULE AND SPECIFICATIONS FOR ADDITIONAL INFORMATION.
- LIGHTING CONTROL NETWORK POWER PACK - SEE LIGHTING CONTROL DEVICE SCHEDULE AND SPECIFICATIONS FOR ADDITIONAL INFORMATION. LOCATE ABOVE NEAREST ACCESSIBLE CEILING. PROVIDE ALL REQUIRED LOW VOLTAGE AND LINE VOLTAGE CONNECTIONS.
- PROVIDE LINE VOLTAGE WALL BOX OCCUPANCY SENSOR - SEE LIGHTING CONTROL DEVICE SCHEDULE AND SPECIFICATIONS FOR ADDITIONAL INFORMATION.
- CONNECT TO BRANCH CIRCUIT SERVING GENERAL LIGHTING IN SAME ROOM AS EMERGENCY LIGHT. CONNECT BATTERY SENSING LEADS AHEAD OF LOCAL SWITCHING.
- CONNECT EXIT LIGHTS TO EXISTING CIRCUIT SERVING EXIT LIGHTS PRIOR TO REMODEL.
- EXTEND EXISTING FIRE ALARM NOTIFICATION LOOP TO NEW DEVICES AND CONNECT.
- FEED NEW PANEL FROM NEW (1000) CIRCUIT BREAKER IN EXISTING PANEL L101 WITH 4E2R5P-112C.
- PROVIDE FINAL CONNECTION TO WHEEL CHAIR LIFT. COORDINATE LOCATION OF ALL COMPONENTS AND REQUIREMENTS WITH MANUFACTURER PRIOR TO ROUGH IN.
- PROVIDE 1" CEILING SPACE OF PANTRY RAIL BELOW SLAB AND STUBBED UP INTO BASE OF HAND RAIL POST TO ALLOW FOR ROUTING OF LOW VOLTAGE CABLES SERVING RAIL LIGHTING. COORDINATE WITH ARCHITECTURAL AND GENERAL CONTRACTOR PRIOR TO CONSTRUCTION.
- PROVIDE NEW CENTRAL INVERTER - EVENUTE BPW11 12 LC TB OR EQUAL.
- PROVIDE ROUGH IN FOR THERMOSTAT / SENSOR. PROVIDE 1/2" WITH PULL STRING FROM ROUGH IN TO MECHANICAL EQUIPMENT SERVED. COORDINATE REQUIREMENTS WITH MECHANICAL CONTRACTOR PRIOR TO ROUGH IN.
- EXISTING MECHANICAL EQUIPMENT TO REMAIN. MAINTAIN BRANCH CIRCUIT AND PROTECT EQUIPMENT DURING REMODEL.
- EXACT ELECTRICAL REQUIREMENTS NOT KNOWN AT TIME OF DESIGN. COORDINATE REQUIREMENTS WITH EQUIPMENT SUPPLIER PRIOR TO ROUGH IN. MAKE REQUIRED CHANGES AT NO ADDITIONAL COST TO THE OWNER.
- LOCATE SERVICE RECEPTACLE ADJACENT TO EXHAUST FAN. COORDINATE LOCATION WITH MECHANICAL CONTRACTOR AND GENERAL CONTRACTOR PRIOR TO ROUGH IN.
- EQUIPMENT PROVIDED WITH INTEGRAL DISCONNECT. PROVIDE SPARE 1" WITH PULL STRING FROM EQUIPMENT TO HOOD UTILITY CABINET FOR CABBING BY OTHERS. COORDINATE WITH EQUIPMENT MANUFACTURER PRIOR TO ROUGH IN.
- PROVIDE NEW RECEPTACLE FOR WATER SOFTENER. CONNECT TO EXISTING PANEL SERVING SAME ROOM AS WATER SOFTENER. COORDINATE EXACT LOCATION OF RECEPTACLE WITH MECHANICAL CONTRACTOR PRIOR TO ROUGH IN.
- PRE-WIRED KITCHEN HOOD ELECTRICAL TERMINAL BOX WITH TERMINAL STRIPS, 3-PHASE VPDS AND OVERLOADS FOR EXHAUST AND SUPPLY FANS. CONNECTIONS FOR HOOD VFDs, AND HOOD DOWNFLOW CONTROLS. VERIFY LOCATION WITH KITCHEN EQUIPMENT SUPPLIER. PROVIDE BUILDING POWER CONNECTION TO PANEL FOR EACH HOOD FAN AND HOOD LIGHTS, THEN FINAL CONNECTIONS FROM PANEL TO FAN AND LIGHTS. PROVIDE ALL ADDITIONAL LINE VOLTAGE AND LOW VOLTAGE CONNECTIONS NOT INDICATED ON THIS PLAN REQUIRED TO ENSURE HOOD IS OPERATIONAL. COORDINATE ALL REQUIREMENTS WITH REVIEWED HOOD EQUIPMENT SHOP DRAWINGS AND EQUIPMENT MANUFACTURER PRIOR TO ROUGH IN.
- PROVIDE 120V ELECTRICAL CONNECTION TO HOOD ANSUL FIRE SUPPRESSION SYSTEM CONTROL PANEL. UPON ALARM FROM HOOD FIRE DETECTION SYSTEM THE ANSUL SYSTEM CONTROL PANEL SHALL DISCONNECT ELECTRICAL POWER TO ALL EQUIPMENT UNDER HOOD THROUGH SHUNT TRIP CONTROLLED BREAKERS IN PANEL SERVING EQUIPMENT UNDER HOOD.

GENERAL NOTES

- MINIMUM SIZE FOR BRANCH CIRCUIT CONDUITS SHALL BE 1/2" MINIMUM. DATA COMMUNICATIONS CONDUIT SIZE SHALL BE 1". SEE DRAWINGS FOR AREAS WHERE LARGER CONDUITS ARE REQUIRED.
- AT CONTRACTOR'S OPTION, THE USE OF MULTI-WIRE BRANCH CIRCUITS IS ALLOWED. PROVIDE MEANS TO SIMULTANEOUSLY DISCONNECT ALL CIRCUIT BRANCHES SHARING A COMMON NEUTRAL.
- PROVIDE A GREEN INSULATED GROUND WIRE IN ALL LIGHTING AND POWER BRANCH CIRCUITS.
- ALL EXISTING WIRING DEVICES (LIGHTING, POWER AND DATA AS APPLICABLE) LOCATED WITHIN THE SCOPE OF REMODEL SHALL BE REMOVED AND REPLACED WITH NEW AS REQUIRED TO MATCH DEVICE AND FACEPLATE COLORS AND TYPES INDICATED IN ELECTRICAL SPECIFICATIONS.

ME NO: 22488
morrissey engineering inc.
 mechanical | electrical | lighting | technology | consulting
 4740 North 118th Street
 Omaha, NE 68114
 P: 402.491.4144
 www.morrisseyengineering.com

STATE OF NEBRASKA
 PROFESSIONAL ENGINEER
 GEORGE M. MORRISSEY
 E-8874

DATE: 07/24/24
 SHEET: E1.1